
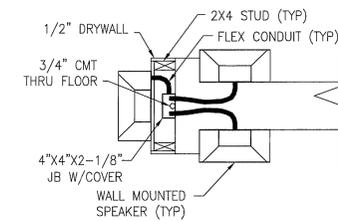


CONTRACTOR PROVIDED EQUIPMENT		
ITEM	QTY.	DESCRIPTION
①	AR.	PA CABLE 600 VAC 1-PR, 16 AWG STRANDED BELDEN #1118A
②	4 EA.	ATLAS SPEAKER MODEL #AP-15TU WITH APX MOUNTING BASE. NO SUBSTITUTE, VENDOR MUST SUPPLY AS SPECIFIED.
③		
④		
⑤		
⑥		

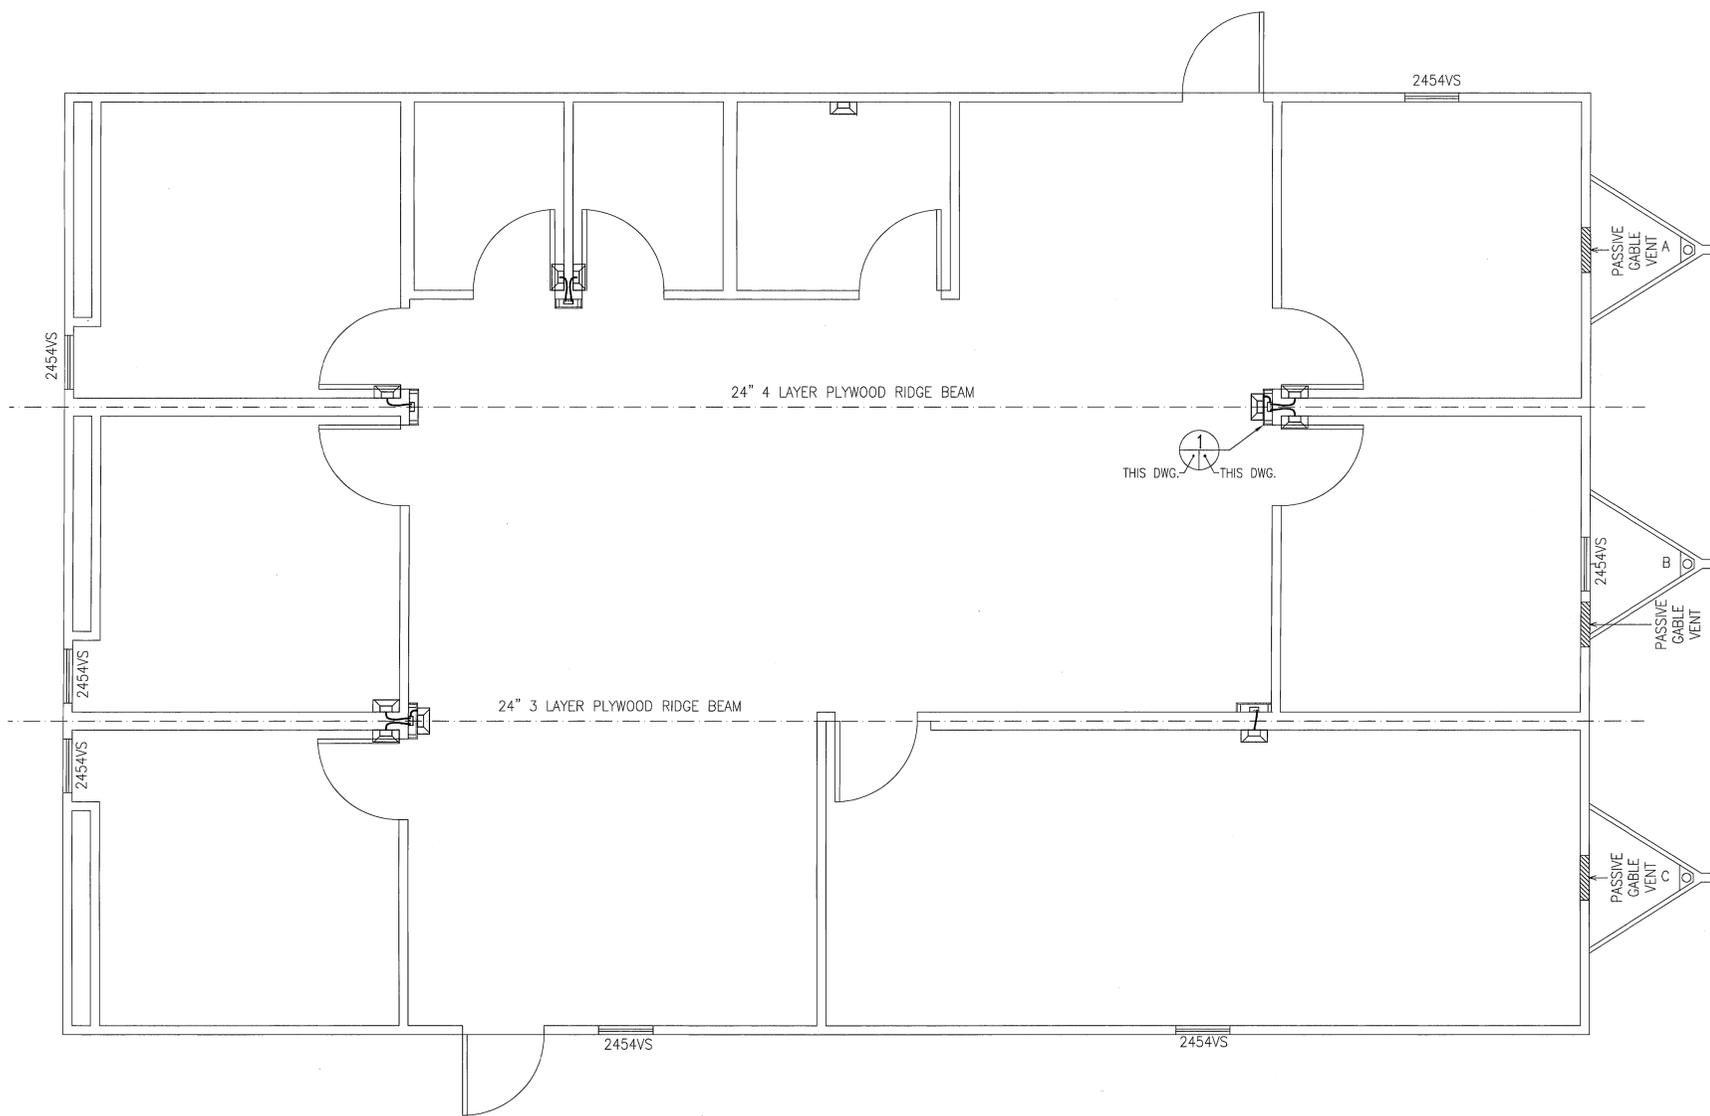

TYPICAL DETAIL
SCALE: 1" = 1'-0" THIS DWG.

LEGEND

- WALL MOUNTED SPEAKER
- SPEAKER AND EVACUATION SW CONNECTION BOX WITH TERMINAL STRIP
- EVACUATION P.B. SWITCH SEE DRAWING XT-104D-3-E FOR EVAC. SW WIRING

FLOOR PLAN
SCALE: 3/8" = 1'-0"

THIS DOCUMENT HAS BEEN REVIEWED AND IS UNCLASSIFIED AND NOT UCN. THIS REVIEW DOES NOT CONSTITUTE CLEARANCE FOR PUBLIC RELEASE.

INFORMATION CONTAINED WITHIN DOES NOT CONTAIN EXPORT CONTROLLED INFORMATION

APPROVED FOR RELEASE
H.H. THOMAS
DATE 11-18-14

REFERENCE DRAWINGS	OPEN CHANGES	REV	REVISION DESCRIPTION	DWN	CHK	DESIGN MANAGER	DATE
XT-104D-1-E XT-104D-2-E XT-104D-3-E XT-104D-4-E							
		A	CFC PER ECR E4858-002	FGG	WU		11-18-14

Fluor-B&W | Portsmouth
P.O. BOX 548 PIKETON, OHIO 45661

NOTICE: THIS DRAWING HAS NOT BEEN PUBLISHED AND IS THE SOLE PROPERTY OF FBP LLC AND IS LENT TO THE BORROWER FOR THEIR CONFIDENTIAL USE ONLY, AND IN CONSIDERATION OF THE LOAN OF THIS DRAWING, THE BORROWER PROMISES AND AGREES TO RETURN IT UPON REQUEST AND AGREES THAT IT WILL NOT BE REPRODUCED, COPIED, LENT OR OTHERWISE DISPOSED OF DIRECTLY OR INDIRECTLY, NOR USED FOR ANY PURPOSE OTHER THAN THAT FOR WHICH IT IS FURNISHED.

CONTRACT DEAC3010CC40017
DRAWN BY S. WILLIAMS
CHECKED BY B. SOMMER
DATE 11-18-14

PORTSMOUTH GASEOUS DIFFUSION PLANT D & D PROJECT

XT-104D TRIPLEX TRAILER PA PLAN AND DETAILS

FACILITY XT-104D DRAWING NUMBER XT-104D-E-30175